


APPENDIX B

PHOTOMETRIC PLAN

This page intentionally left blank

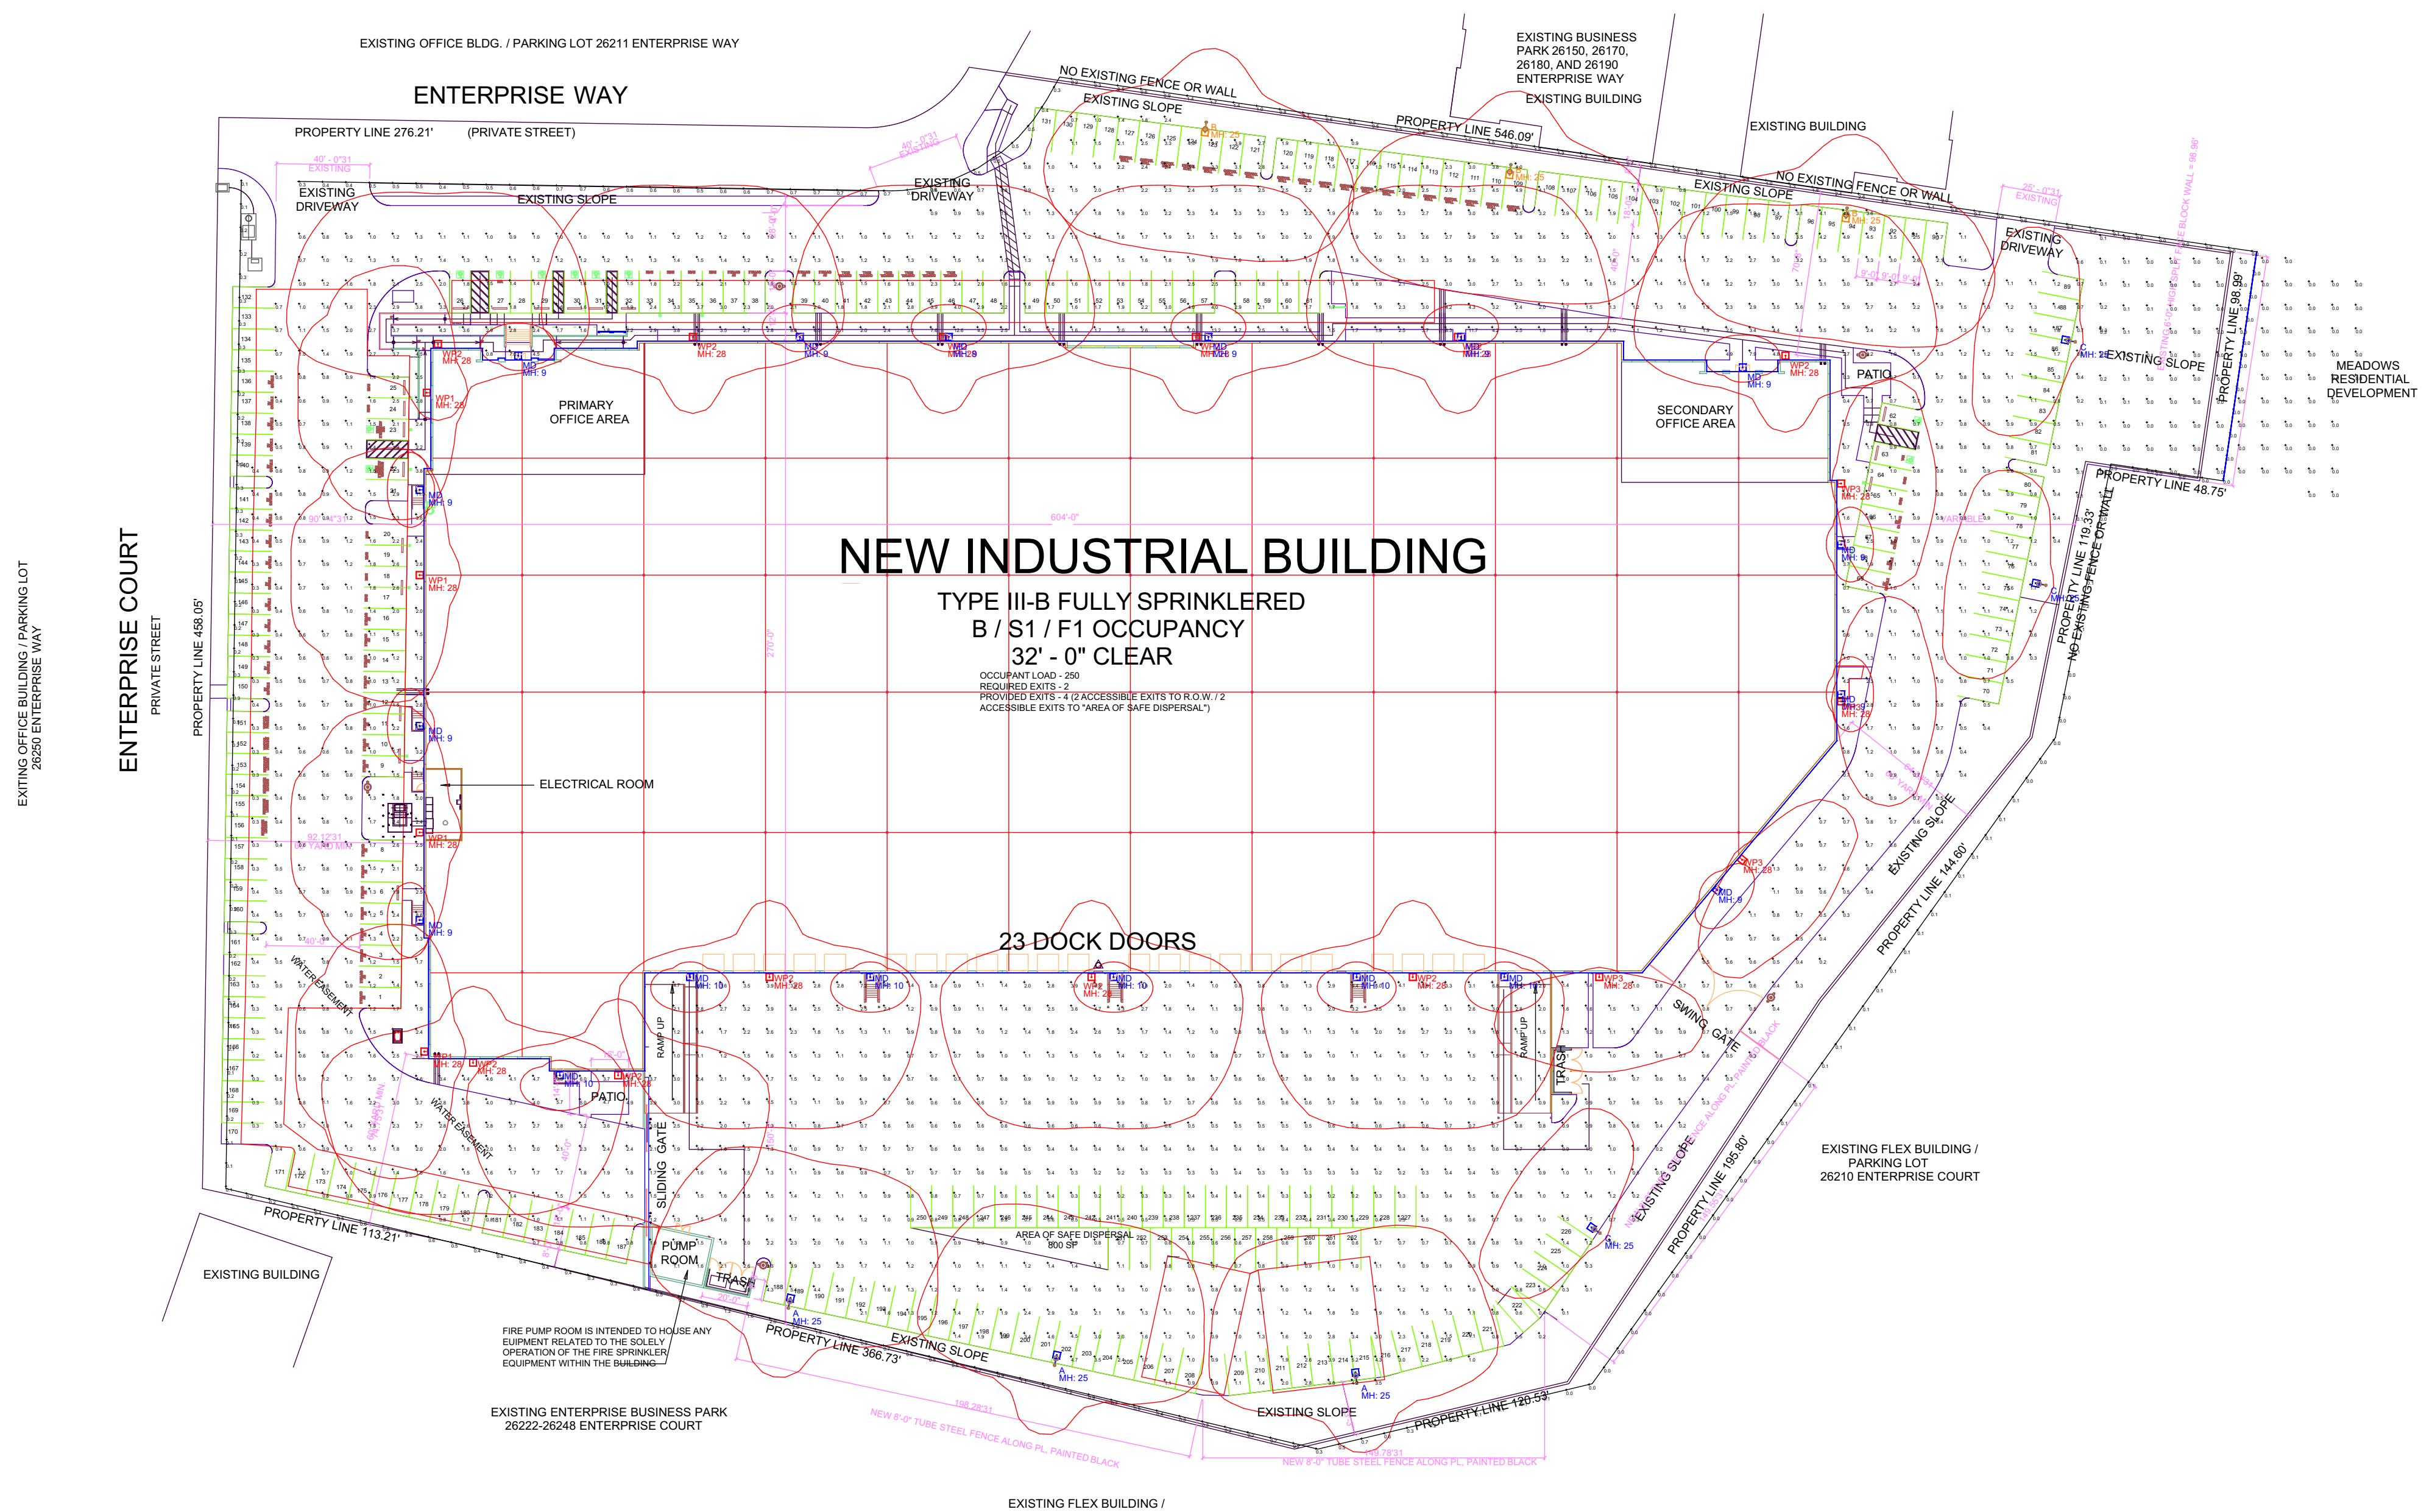

2622U EN1

Calculation Summary							
Label	CalcType	Units	Avg	Max	Min	Avg/Min	Max
CALC AREA	Illuminance	Fc	1.57	13.2	0.1	15.70	132.
LIGHT SPILL	Illuminance	Fc	0.05	0.6	0.0	N.A.	N.A.
LIGHT SPILL PAST THE 6FT WALL	Illuminance	Fc	0.00	0.0	0.0	N.A.	N.A.
PROPERTY LINE	Illuminance	Fc	0.44	2.6	0.0	N.A.	N.A.
CAR STALLS	Illuminance	Fc	2.35	4.0	1.6	1.47	2.50
CAR STALLS_1	Illuminance	Fc	0.96	2.9	0.2	4.80	14.5
MANDOOR	Illuminance	Fc	4.20	4.2	4.2	1.00	1.00
TRUCK STALLS	Illuminance	Fc	1.80	5.2	0.8	2.25	6.50

Luminaire Schedule															
Symbol	Qty	Label	Arrangement	Total Lamp Lumens	LLF	Description					Total Watts	BUG Rating	Lum. Watts		
	4	WP3	SINGLE	N.A.	0.900	RSX1 LED P1 40K R3 HS					205.374	B1-U0-G2	51.3435		
	3	C	SINGLE	N.A.	0.900	RSX1 LED P1 40K R3 HS					154.03	B1-U0-G2	51.3435		
	3	B	SINGLE	N.A.	0.900	RSX2 LED P2 40K R3					342.213	B3-U0-G3	114.071		
	11	WP2	SINGLE	N.A.	0.900	RSX2 LED P2 40K R4					1254.781	B2-U0-G3	114.071		
	18	MD	SINGLE	N.A.	0.900	WST LED P1 40K VW MVOLT					216	B0-U0-G0	12		
	3	A	SINGLE	N.A.	0.900	RSX2 LED P2 40K R4					342.213	B2-U0-G3	114.071		
	4	WP1	SINGLE	N.A.	0.900	RSX2 LED P1 40K R4					288.24	B2-U0-G2	72.06		

1 PhotoMetric Plan


1 SCALE: 1" = 5'

**NOTE 1 - (NATIONAL ACCOUNT) FIXTURE PACKAGE PRICING PROVIDED BY TURTLE AND HUGHES.
PLEASE CONTACT (909) 218-8644 OR EMAIL JESSICA.FISHEL@TURTLE.COM FOR FIXTURE AND CONTROLS PRICING**

TURTLE & HUGHES, INC. FIRST IN THE LONG RUN

ELECTRICAL & INDUSTRIAL DISTRIBUTOR

1550 S. MILLIKEN AVE., SUITE F, ONTARIO, CA 91761
P: 909.218.8644 F: 909.218.8637

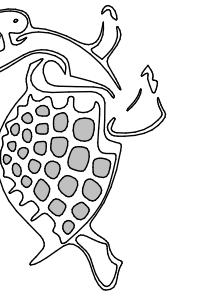

Turtle & Hughes
1551 S. Milliken Ste. F
Ontario, CA 91761

Enterprise Way

te Project No.
3/2024 -
Sheet Title
**HOTOMETRIC
.AN
*Sheet No.***
P-SL-6
Released for Construction
Not Released for Construction

This page intentionally left blank